






X1

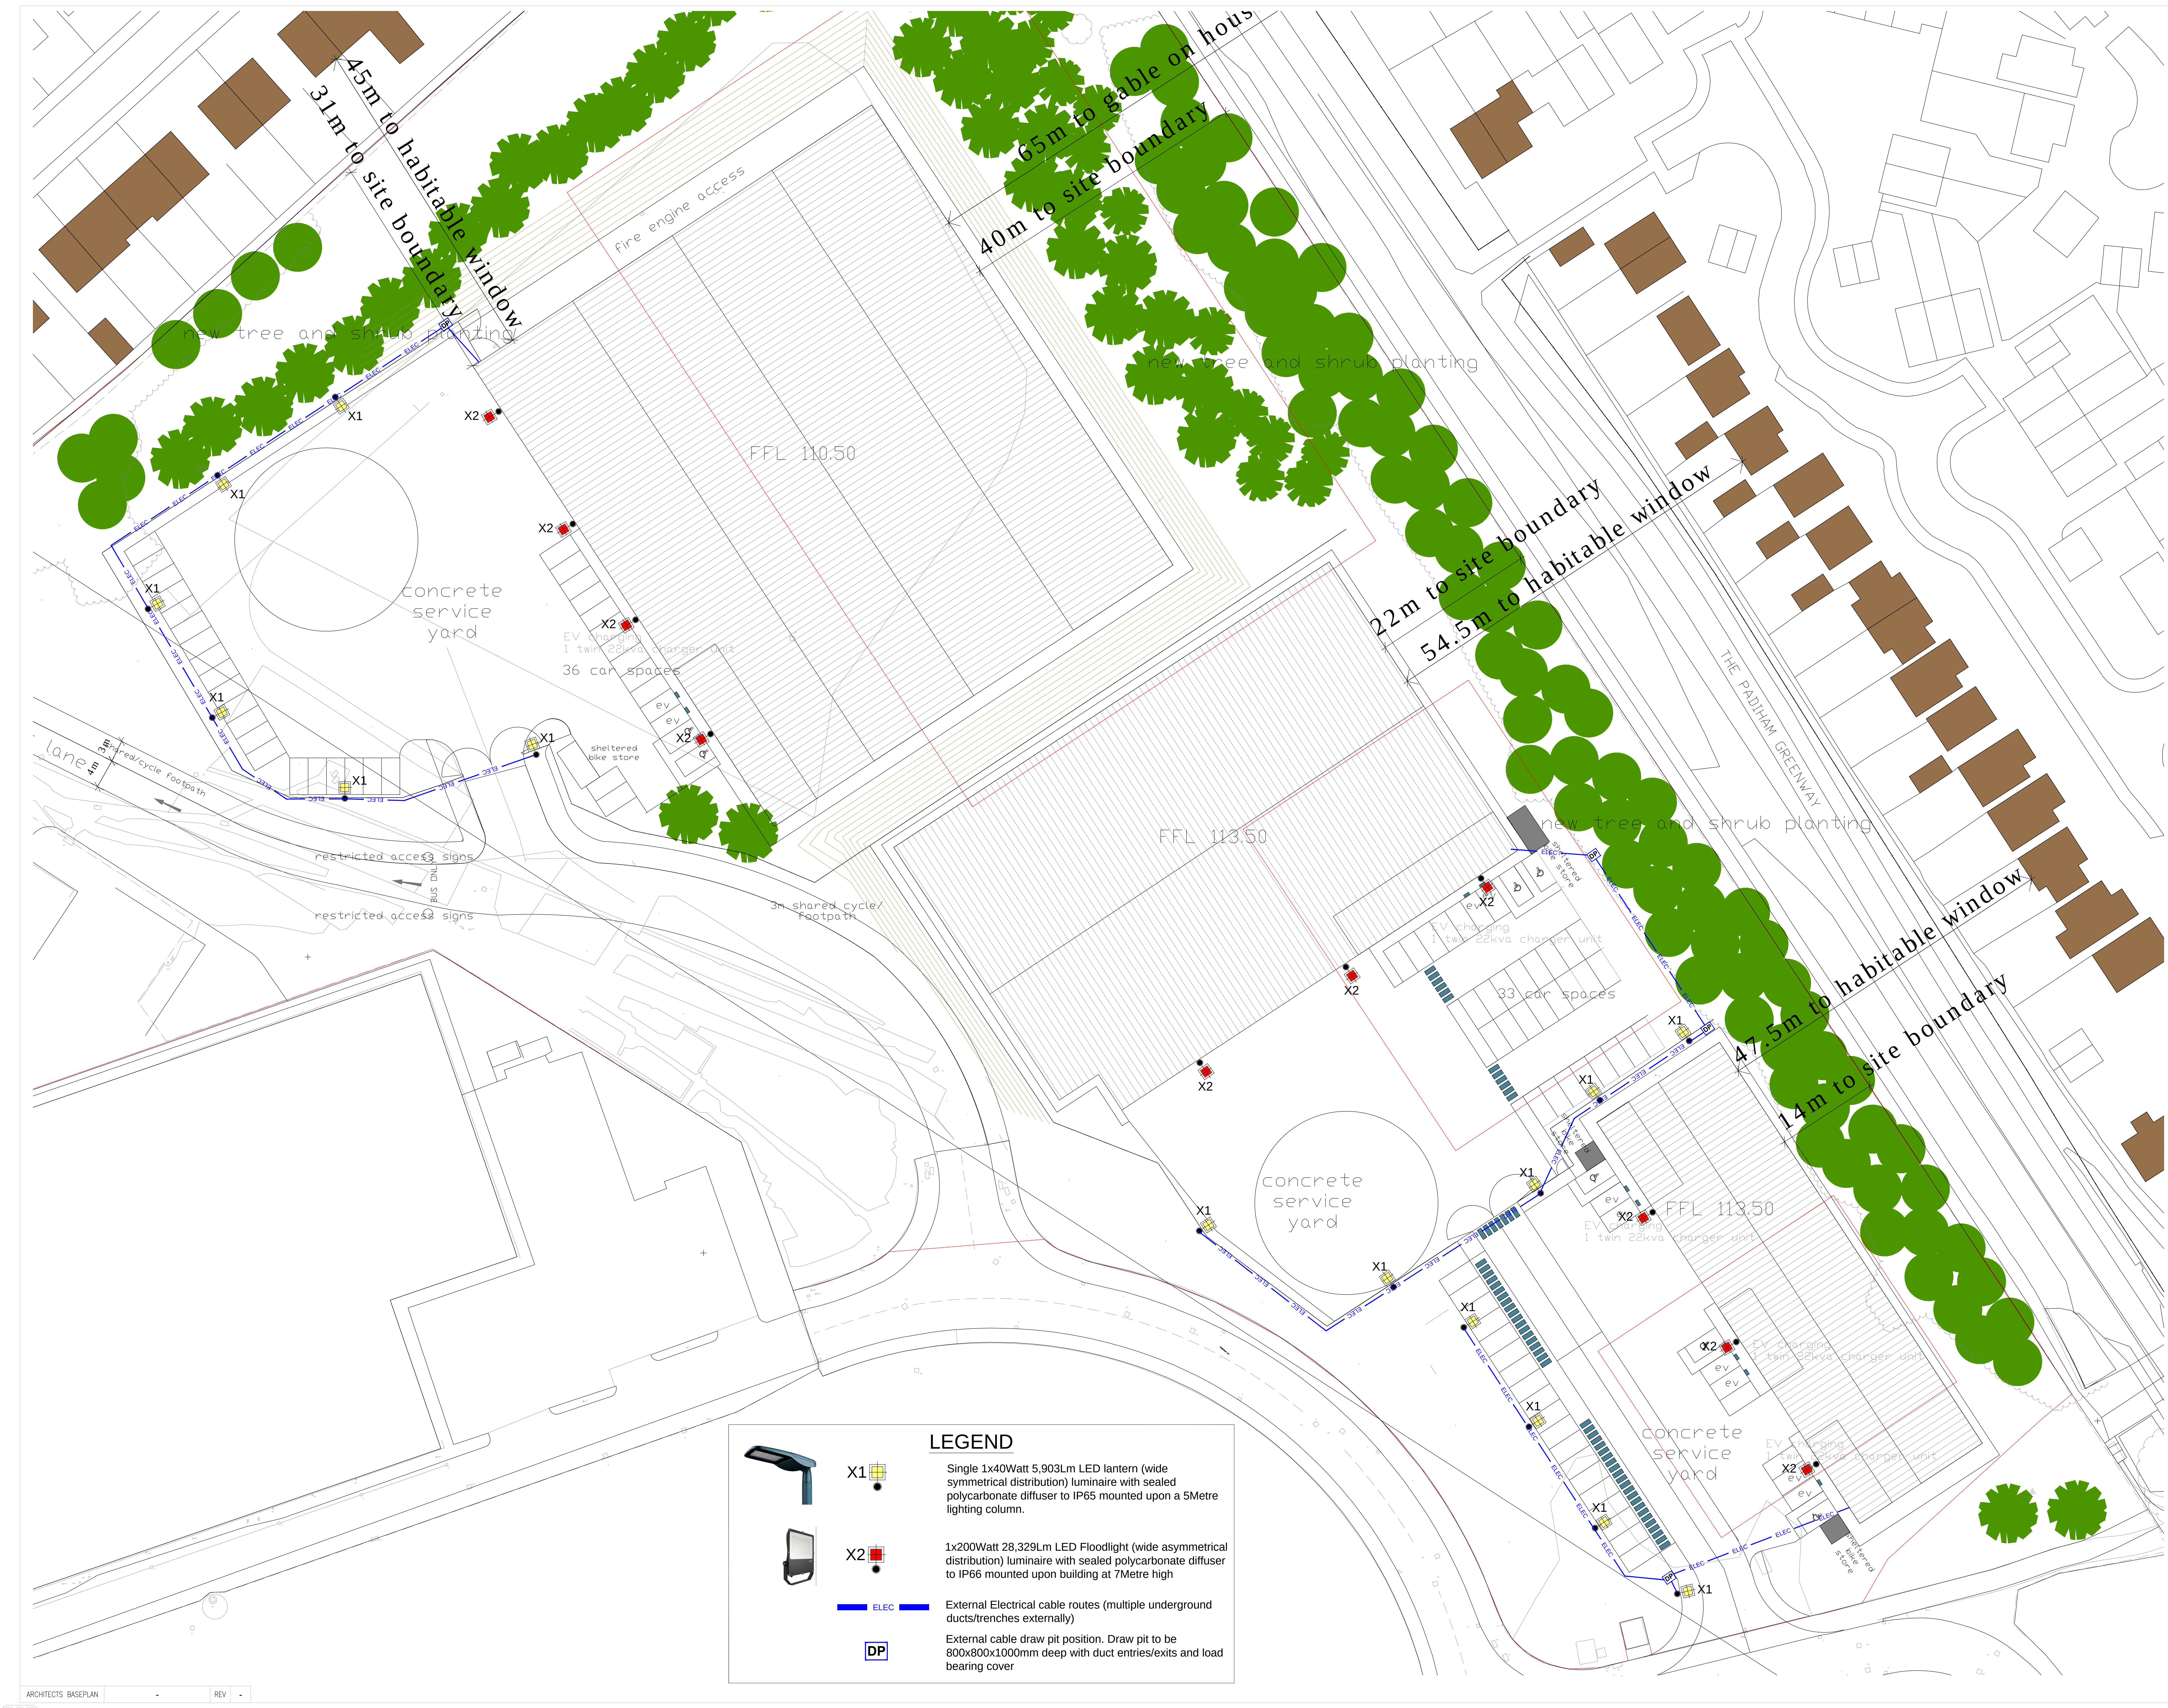

X2



ELEC



DP

LEGEND

Single 1x40Watt 5,903Lm LED lantern (wide symmetrical distribution) luminaire with sealed polycarbonate diffuser to IP65 mounted upon a 5Metre lighting column.

1x200Watt 28,329Lm LED Floodlight (wide asymmetrical distribution) luminaire with sealed polycarbonate diffuser to IP66 mounted upon building at 7Metre high

External Electrical cable routes (multiple underground ducts/trenches externally)

External cable draw pit position. Draw pit to be 800x800x1000mm deep with duct entries/exits and load bearing cover

P1	PROVISIONAL ISSUE FOR COMMENT	14/12/21	TMC	AMC	AK
REV	DESCRIPTION	DATE	DRN	CHD	APPD
STATUS					
PRELIMINARY ISSUE					
CONTRACT					
BURNLEY BRIDGE BUSINESS PARK					
CLIENT					
MONTE BLACKBURN					
DATE	14/12/21	SCALE	NTS		
DRAWN	T.McKay	JOB No.	DRG No.	REV	
CHECKED	A. McKay	2474	(66) 602	A	
APPROVED	A. Kershaw				
TITLE					
CAR PARKING AND ACCESS LIGHTING LAYOUT					



Caroline Court, Ellington Road
Burnley, Lancashire, BB11 5UB
Tel: 01282 415 864
www.speakmancontractors.co.uk

THIS DRAWING IS CONFIDENTIAL & IS THE PROPERTY OF SPEAKMAN CONTRACTORS LTD. IT MUST NOT BE REPRODUCED OR IN ANY MANNER COPIED OR LENT WITHOUT THEIR WRITTEN CONSENT.